

1 1ST FLOOR LIGHTING PLAN
Scale: 1/4" = 1'-0"

CAN LIGHTS VARIOUS 4" RECESSED CAN LIGHTS, TBD GAS LIT PENDANT FIXTURE A COVERED ENTRY FIXTURE B **GREAT ROOM** CEILING FAN (NO LIGHT KIT) FIXTURE C SCREENED PORCH CEILING FAN (NO LIGHT KIT) FIXTURE D DINING DECORATIVE CHANDELIER OVERSIZED PENDANT FIXTURE E KITCHEN ISLAND FIXTURE F POWDER ROOM DECORATIVE FIXTURE FIXTURE G LAUNDRY CEILING MOUNT FIXTURE H PRIMARY BEDROOM CEILING FAN (NO LIGHT KIT) FIXTURE I PRIMARY BATH WALL SCONCE FIXTURE J STAIRCASE WALL SCONCE FIXTURE K GARAGE EXTERIOR WALL SCONCE FIXTURE L BEDROOM 2 CEILING FAN W/ LIGHT KIT FIXTURE M BATH 2 VANITY LIGHT CEILING FAN W/ LIGHT KIT FIXTURE N BEDROOM 3 FIXTURE O BATH 3 VANITY LIGHT FIXTURE P COVERED LANDING CEILING MOUNT FIXTURE Q IN-LAW SUITE BEDROOM CEILING FAN W/ LIGHT KIT FIXTURE R IN-LAW SUITE BATH VANITY LIGHT

LIGHTING LEGEND			
SYMBOL	DESCRIPTION		
	CEILING FAN WITH LIGHT KIT		
	WALL SCONCE		
\otimes	DECORATIVE FIXTURE		
	RECESSED EXHAUST FAN ONLY		
•	RECESSED EXHAUST/CAN COMBO		
¤	RECESSED CAN		
00	VANITY LIGHT		
	UNDER CABINET LIGHT		
LED	LED LIGHT		





414 Arboretum Drive Wilmington, NC 28405

910-679-4179 www.gingerinteriordesign.com www.schmidtcustombuilders.com

COASTAL CREATION- LOT 144 3217 SUNSET BEND COURT WILMINGTON, NC 28409

revisions:
1. ADDED RECESSED CANS

notes:

drawn by: JH


date: 8/25/24

drawing title:

1ST FLOOR LIGHTING PLAN

sheet no.:

D-1

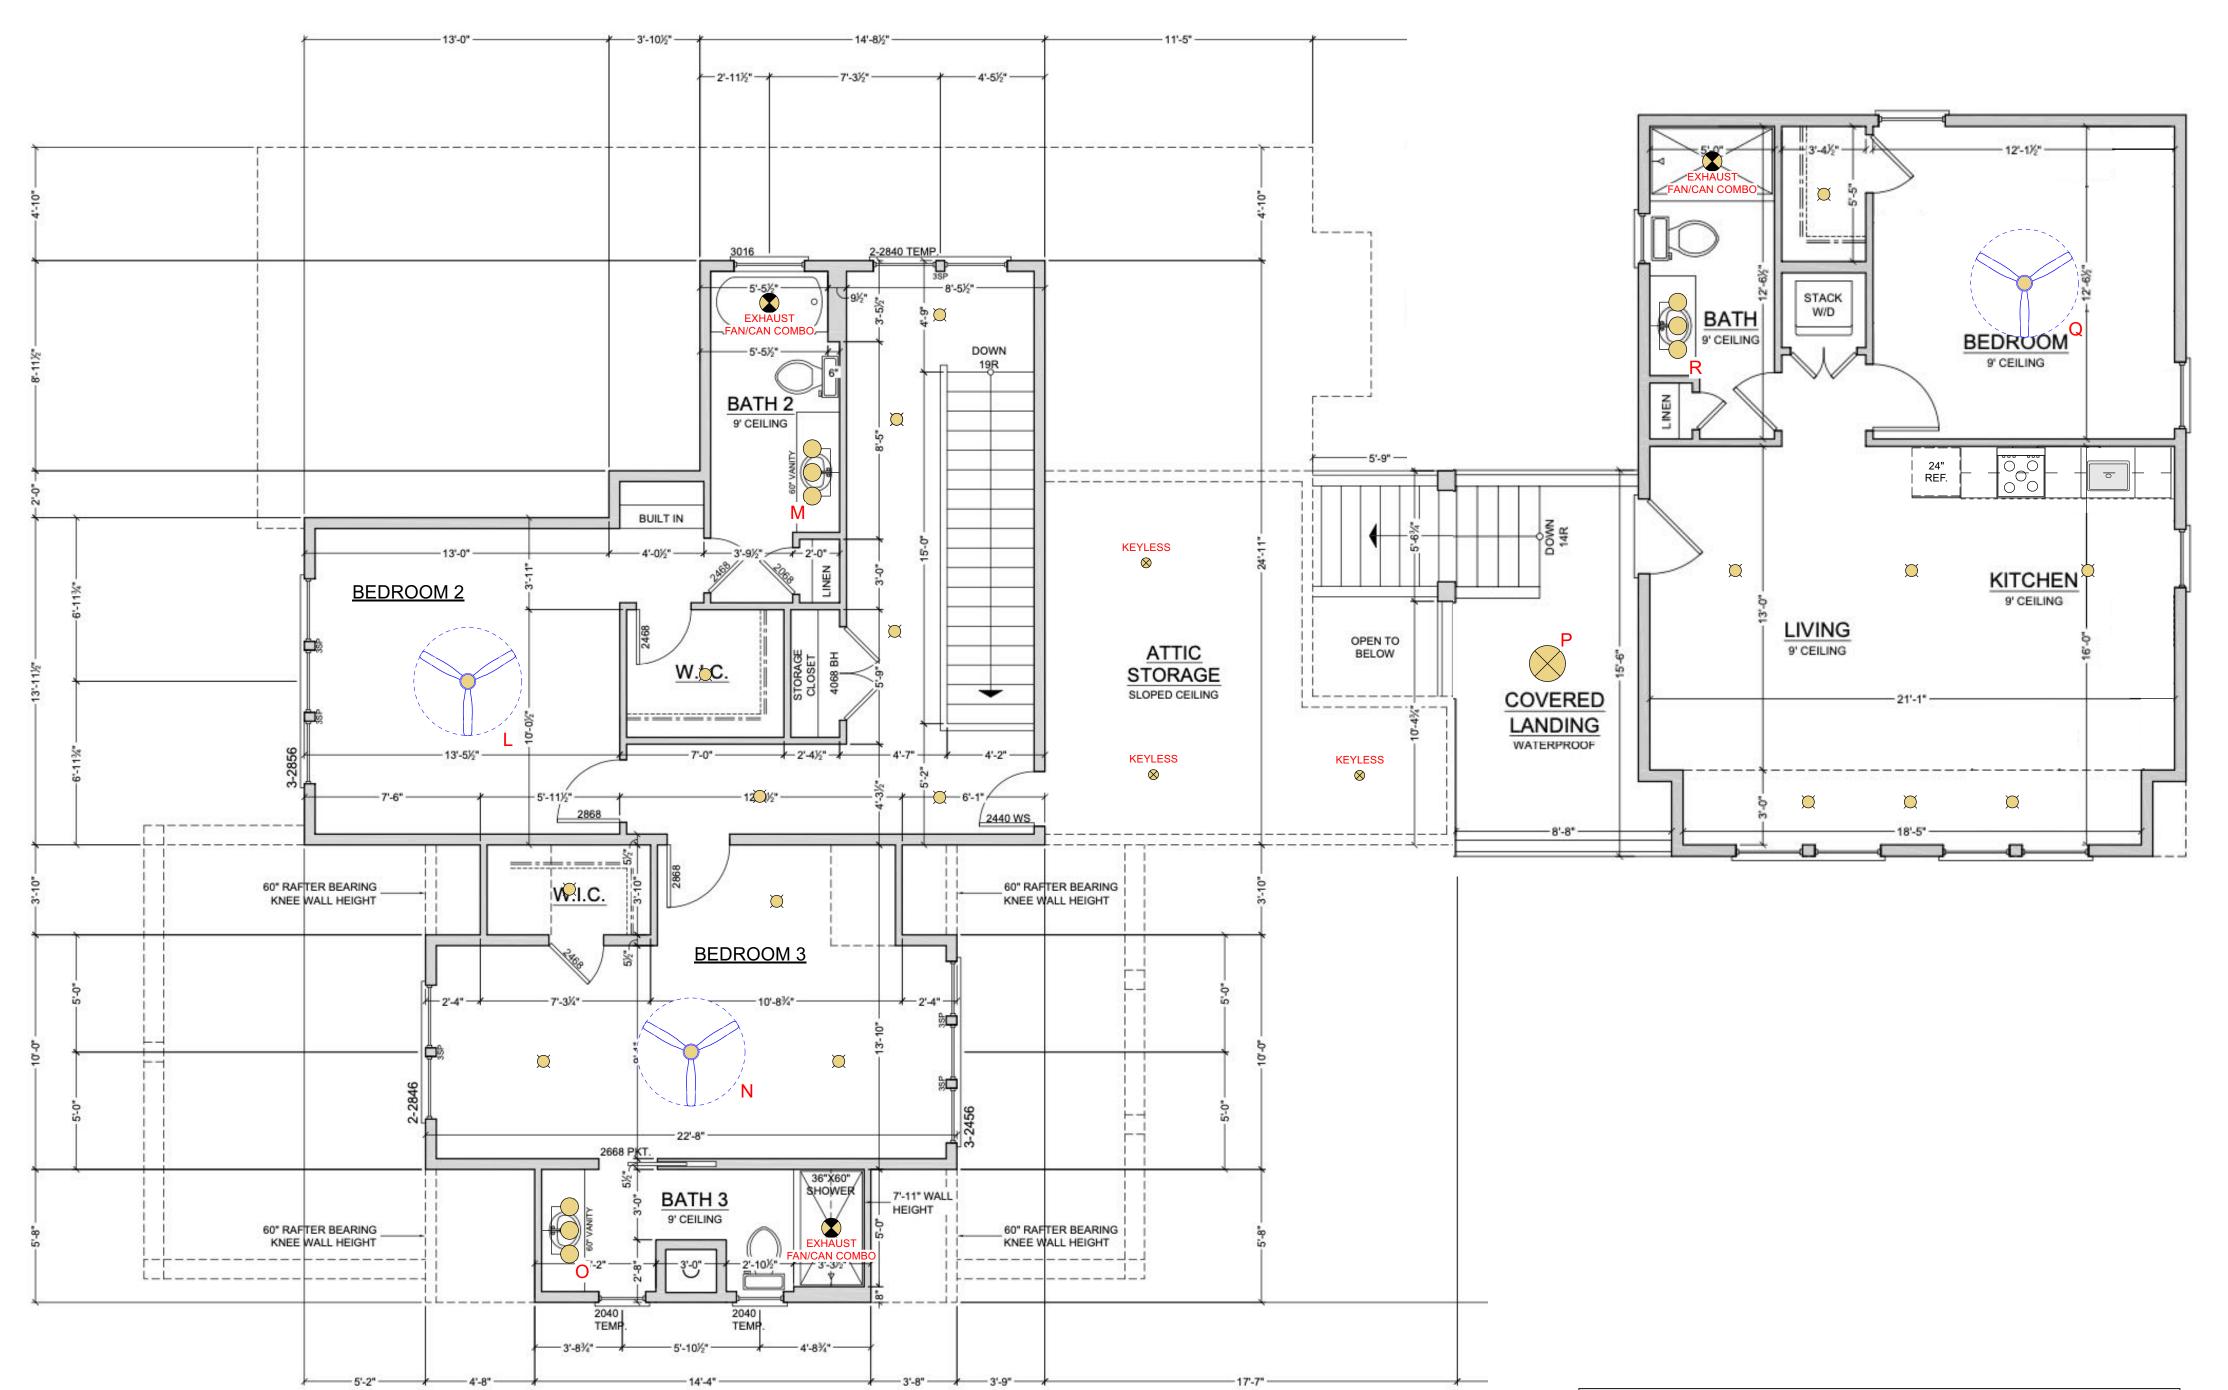

2ND FLOOR LIGHTING PLAN
Scale: 1/4" = 1'-0"

LIGHT FIXTURE LEGEND				
CAN LIGHTS	VARIOUS	4" RECESSED CAN LIGHTS, TBD		
FIXTURE A	COVERED ENTRY	GAS LIT PENDANT		
FIXTURE B	GREAT ROOM	CEILING FAN (NO LIGHT KIT)		
FIXTURE C	SCREENED PORCH	CEILING FAN (NO LIGHT KIT)		
FIXTURE D	DINING	DECORATIVE CHANDELIER		
FIXTURE E	KITCHEN ISLAND	OVERSIZED PENDANT		
FIXTURE F	POWDER ROOM	DECORATIVE FIXTURE		
FIXTURE G	LAUNDRY	CEILING MOUNT		
FIXTURE H	PRIMARY BEDROOM	CEILING FAN (NO LIGHT KIT)		
FIXTURE I	PRIMARY BATH	WALL SCONCE		
FIXTURE J	STAIRCASE	WALL SCONCE		
FIXTURE K	GARAGE EXTERIOR	WALL SCONCE		
FIXTURE L	BEDROOM 2	CEILING FAN W/ LIGHT KIT		
FIXTURE M	BATH 2	VANITY LIGHT		
FIXTURE N	BEDROOM 3	CEILING FAN W/ LIGHT KIT		
FIXTURE O	BATH 3	VANITY LIGHT		
FIXTURE P	COVERED LANDING	CEILING MOUNT		
FIXTURE Q	IN-LAW SUITE BEDROOM	CEILING FAN W/ LIGHT KIT		
FIXTURE R	IN-LAW SUITE BATH	VANITY LIGHT		

LIGHTING LEGEND			
SYMBOL	DESCRIPTION		
	CEILING FAN WITH LIGHT KIT		
	WALL SCONCE		
\bigotimes	DECORATIVE FIXTURE		
	RECESSED EXHAUST FAN ONLY		
	RECESSED EXHAUST/CAN COMBO		
¤	RECESSED CAN		
00	VANITY LIGHT		
	UNDER CABINET LIGHT		
LED	LED LIGHT		
	LED LIGHT		





414 Arboretum Drive Wilmington, NC 28405 910-679-4179

910-679-4179 www.gingerinteriordesign.com www.schmidtcustombuilders.com

project information:

COASTAL CREATION- LOT 144
3217 SUNSET BEND COURT
WILMINGTON, NC 28409

note

drawn by: JH


drawing title:

2ND FLOOR LIGHTING PLAN

8/25/24

sheet no.:

ID-2

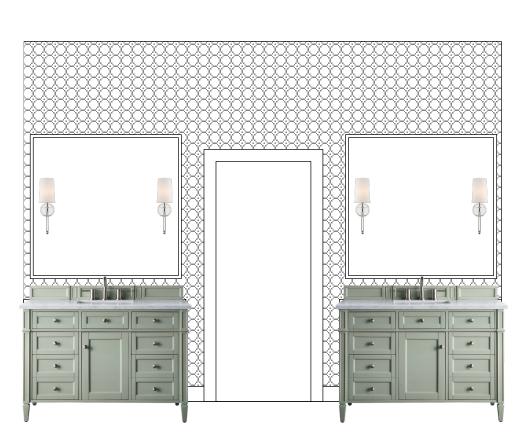

1 PRIMARY BATH - VANITY WALL
Scale: 3/8" = 1'-0"

GINGER

INTERIORS | JO HOWELL



414 Arboretum Drive Wilmington, NC 28405 910-679-4179

910-6/9-41/9 www.gingerinteriordesign.com www.schmidtcustombuilders.com

> COASTAL CREATION- LOT 144 3217 SUNSET BEND COURT WILMINGTON, NC 28409

Preliminary Construction Plans

revisions:

1. REFRAME / NEW PRIMARY
BATH LAYOUT - 1.15.24

note

drawn by: JCC

date: 6/6

drawing title:

ELEVATIONS

sheet no.:

ID-3